

PROJECT TEAM

OWNER:
SUN LUCIE POOL LLC
101 W 55TH STREET
NEW YORK, NY 10019

DEVELOPER:
10575 S US HWY 1 LLC
8910 TWO NOTCH ROAD, 5TH FLOOR
COLUMBIA, SC 29223

ENGINEER:
CPH INC.
1992 SW 1ST STREET
MIAMI, FL 33135

LANDSCAPE ARCHITECT:
CPH INC.
1992 SW 1ST STREET
MIAMI, FL 33135

SURVEY:
ENGINEERING DESIGN & CONSTRUCTION INC.
10250 VILLAGE PARKWAY SUITE 201
PORT ST. LUCIE, FL 34987

SITE DATA

LEGAL DESCRIPTION:
COMMENCING AT THE INTERSECTION OF THE WESTERLY RIGHT-OF-WAY OF U.S. HIGHWAY NO. 1, AS IT NOW EXISTS AND THE NORTH RIGHT-OF-WAY OF PORT ST. LUCIE BOULEVARD, AS IT NOW EXISTS; THENCE N 27°53'31" W, ALONG THE SAID WESTERLY RIGHT-OF-WAY LINE OF U.S. HIGHWAY NO. 1, 262.93 FEET TO THE POINT-OF-BEGINNING OF THE FOLLOWING DESCRIBED PARCEL OF LAND, THENCE N 27°53'31" W, ALONG THE SAID WESTERLY RIGHT-OF-WAY OF U.S. HIGHWAY NO. 1, 187.96 FEET; CO THENCE S 89°22'54" E, 364.81 FEET; THENCE S 19°30'40" E, 226.0 FEET; THENCE S 89°56'45" E, ALONG THE SAID NORTH RIGHT-OF-WAY LINE OF PORT ST. LUCIE BOULEVARD, 175.0 FEET; THENCE N 00°03'11" E, 158.15 FEET; THENCE N 82°09'29" E, 158.15 FEET TO THE POINT-OF-BEGINNING. ALL OF SAID LAND LYING AND SITUATE IN SECTION 12, TOWNSHIP 37 SOUTH, RANGE 40 EAST, ST. LUCIE COUNTY, FLORIDA.

LESS AND EXCEPT:
COMMENCING AT THE INTERSECTION OF THE WESTERLY RIGHT-OF-WAY OF U.S. HIGHWAY NO. 1, AS IT NOW EXISTS AND THE NORTH RIGHT-OF-WAY OF PORT ST. LUCIE BLVD, AS IT NOW EXISTS, THENCE N 27°53'31" WEST ALONG THE WESTERLY RIGHT-OF-WAY LINE OF U.S. HIGHWAY NO. 1, A DISTANCE OF 450.89 FEET, THENCE SOUTH 89°22'54" WEST A DISTANCE OF 269.89 FEET TO THE POINT OF BEGINNING, THENCE CONTINUE SOUTH 89°22'54" WEST A DISTANCE OF 84.92 FEET, THENCE SOUTH 19°30'40" E, A DISTANCE OF 225.00 FEET TO THE NORTH RIGHT-OF-WAY OF PORT ST. LUCIE BLVD., THENCE SOUTH 89°56'45" EAST ALONG THE NORTH RIGHT-OF-WAY OF PORT ST. LUCIE BLVD., A DISTANCE OF 175.00 FEET, THENCE NORTH 0°03'11" EAST A DISTANCE OF 88.27 FEET, THENCE NORTH 63°02'41" WEST A DISTANCE OF 139.98 FEET, THENCE NORTH 41°52'44" WEST A DISTANCE OF 60.31 FEET, THENCE NORTH 12°05'17" WEST A DISTANCE OF 61.50 FEET TO THE POINT OF BEGINNING. ALL OF SAID LAND LYING AND SITUATE IN SECTION 12, TOWNSHIP 37 SOUTH, RANGE 40 EAST, ST. LUCIE COUNTY, FLORIDA.

TOGETHER WITH THOSE EASEMENTS AS SET OUT IN THE GRANT OF EASEMENT BETWEEN GENERAL DEVELOPMENT CORPORATION, A DELAWARE CORPORATION AUTHORIZED TO DO BUSINESS IN THE STATE OF FLORIDA AND HERITAGE FEDERAL SAVINGS AND LOAN ASSOCIATION OF DAYTONA BEACH, A FLORIDA CORPORATION, ITS SUCCESSORS AND ASSIGNS RECORDED IN OFFICIAL RECORDS BOOK 316, PAGE 313, AND AGREEMENT RECORDED IN OFFICIAL RECORDS BOOK 365, PAGE 342

TOGETHER WITH AN EASEMENT FOR INGRESS/EGRESS AS SET OUT GRANT OF EASEMENT BETWEEN TOWN CENTRE/EAST GATE ASSOCIATES, LTD., F/K/A WEST-LANDCOM DEVELOPERS, LTD., A FLORIDA LIMITED PARTNERSHIP, DIVALL INSURED INCOME PROPERTIES 2 LIMITED PARTNERSHIP, A WISCONSIN LIMITED PARTNERSHIP TO SUN BANK/TREASURY COAST, NATIONAL ASSOCIATION, A NATIONAL BANKING CORPORATION RECORDED IN OFFICIAL RECORDS BOOK 591, PAGE 2856, AND AS MODIFIED BY MODIFICATION OF EASEMENT RECORDED IN OFFICIAL RECORDS BOOK 671, PAGE 1307

TOGETHER WITH THOSE EASEMENTS AS SET OUT IN THE DRAINAGE EASEMENT BETWEEN TOWNE CENTRE/EAST GATE ASSOCIATES, LTD., FORMERLY KNOWN AS WEST-LANDCOM DEVELOPERS, LTD., A FLORIDA LIMITED PARTNERSHIP TO SUN BANK/TREASURY COAST, NATIONAL ASSOCIATION, A NATIONAL BANKING CORPORATION, SUCCESSOR BY MERGER TO SUN BANK OF ST. LUCIE COUNTY, A FLORIDA BANKING CORPORATION, RECORDED IN OFFICIAL RECORDS BOOK 810, PAGE 1672

BUILDING COVERAGE:
PROPOSED: 6,396 S.F. 12.65%
MAXIMUM ALLOWED: 20,216 S.F. 40%, PROVIDED THAT THE COMBINED AREA COVERAGE OF ALL IMPERVIOUS SURFACES SHALL NOT EXCEED 80%

PROJECT NOTES

UTILITY PROVIDERS:
WATER & WASTEWATER: PSLUSD
IRRIGATION: N/A (PROPOSED)
SOLID WASTE: WASTEPRO
ELECTRIC: FP

STORM WATER DRAINAGE: THE SURFACE WATER MANAGEMENT SYSTEM FOR THE PROJECT WILL COLLECT SITE RUNOFF IN A SERIES OF INLETS WHICH WILL ROUTE RUNOFF TO A RETENTION AREA WHICH ULTIMATELY OUTFALLS TO AN EXISTING DRAINAGE SYSTEM.

WATER: EXISTING WATER SERVICE WILL BE UTILIZED TO SERVE THE PROPOSED BUILDING.

SEWER: PROPOSED PUBLIC LIFT STATION WILL BE UTILIZED TO SERVE THE PROPOSED BUILDING.

FIRE PROTECTION: EXISTING FIRE HYDRANTS SHOWN ON THE PLAN VIEW. EXISTING FIRE HYDRANT IS ROUGHLY 185' TO THE CLOSEST POINT OF THE PROPOSED BUILDING.

HAZARDOUS WASTE: ALL HAZARDOUS WASTES DISPOSAL SHALL COMPLY WITH ALL FEDERAL, STATE, AND LOCAL REGULATIONS.

SOLID WASTE: BASED ON THE INTENDED USE OF THE BUILDING, THIS PROJECT WILL UTILIZE A PROPOSED DUMPSTER AREA FOR SOLID WASTE AND RECYCLABLE ITEMS.

LANDSCAPE: PROPOSED LANDSCAPE PLANS TO ADHERE WITH CITY OF PORT ST. LUCIE LAND DEVELOPMENT CODE.

ENVIRONMENTAL: AN ENVIRONMENTAL ASSESSMENT WILL BE PROVIDED DURING CONSTRUCTION PLAN SUBMITTAL.

ACCESSIBILITY AND ADA COMPLIANCE: ALL SIDEWALKS AND RAMPS WILL MEET FOOT AND ADA REQUIREMENTS.

A/C UNITS: ALL A/C UNITS TO BE LOCATED ON THE ROOF.

SIGNAGE: SIGNAGE IS SEPARATE REVIEW FOR APPROVAL.


TRAFFIC STATEMENT: THE ITE TRIP GENERATION MANUAL, 11TH EDITION, LAND USE CODE 945 (CONVENIENCE STORE/GAS STATION) WAS USED TO DETERMINE EXPECTED GROSS DAILY AND PEAK HOUR TRIPS FOR THE PROPOSED PROJECT.

PARKING DATA

REQUIRED PARKING (ADA): 1 SPACE/ 25 REGULAR SPACES
REQUIRED PARKING: 1 SPACE / 200 SF OF GFA
REQUIRED PARKING: 15 SPACES
PROPOSED PARKING: 17 SPACES
REQUIRED PARKING (ADA): 1 SPACE
PROPOSED PARKING (ADA): 1 SPACE
PROPOSED PARKING (EV): 0 SPACES
PROPOSED LOADING ZONE: 0 SPACES

PROVIDED FLOOR AREA RATIO: 0.12
REQUIRED FLOOR AREA RATIO: N/A

ZONING: LAND USE:
NORTH: PUD COMMERCIAL
SOUTH: CG COMMERCIAL
EAST: (R-O-W) (R-O-W)
WEST: CG COMMERCIAL

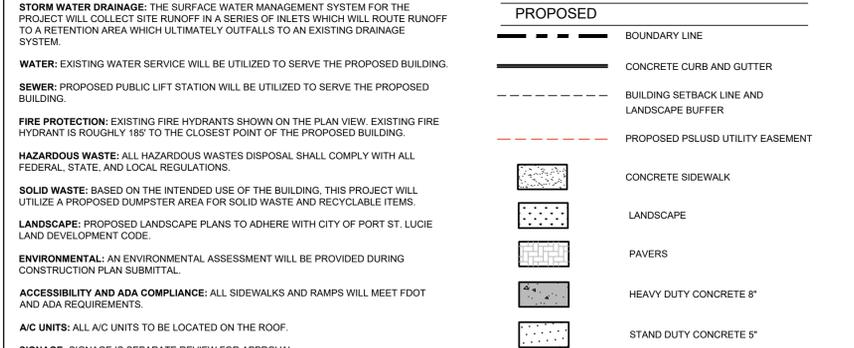


PRE-CONSTRUCTION

Land Use	Trip Generation (Peak Hour of Generator)			PM Peak Hour		
	Intensity	Daily Traffic	AM Peak Hour	In	Out	Total
Gas Station	12 FP's	3,181	99	99	198	115
Gross Traffic		3,181	99	99	198	115

IMPERVIOUS SITE RATIO (ISR)		
AREA	SQUARE SF	%
IMPERVIOUS PAVEMENT	38,289	75
GREEN SPACE	12,508	25
TOTAL SITE	50,797	100

POST-CONSTRUCTION

IMPERVIOUS SITE RATIO (ISR)		
AREA	SQUARE SF	%
IMPERVIOUS (ROOF AND PAVING)	30,250	60
GREEN SPACE	20,547	40
TOTAL SITE	50,797	100

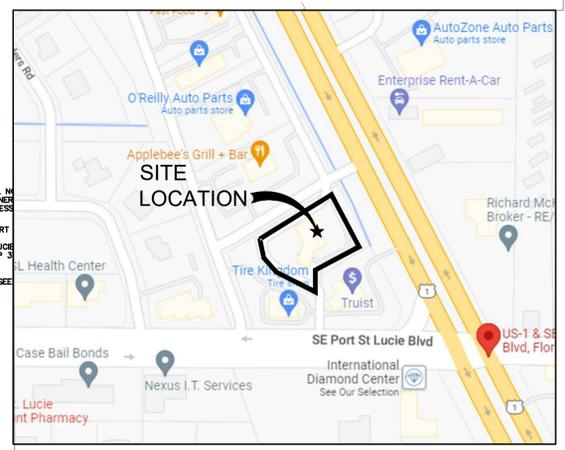

SHEET NO. C-3

JUNE 08, 2023
ANDREW M. DEEGAN, P.E.
FL. P.E. NO. 95482

JOB NO. M3889
Concept 1.0

J.C.H. DRW
A.M.D. DES
A.M.D. PM
6/8/23 DATE
REV-2

SEU CONCEPTUAL SITE PLAN 1 OF 2
MURPHY USA
10575 US HWY 1
PORT SAINT LUCIE
FLORIDA

gph
www.cphcorp.com

A Full Service A & E Firm

Architects
Engineers
Environmental
Landscape Architects
M / E / P
Planners
Surveyors
Traffic / Transportation

Plans Prepared By
CPH, Inc.


1992 SW 1st Street
Miami, FL 33135
Ph: 305.274.4605
Licenses:
Eng. C.O.A. No. 3215
Survey L.B. No. 7143
Arch. Lic. No. AA2600926
Landscape Lic. No. LC0000298

MURPHY OIL USA, INC.


200 PEACH STREET
EL DORADO, AR 71731-7000

MURPHY USA


P23-056
PSLUSD # 11-033-0017

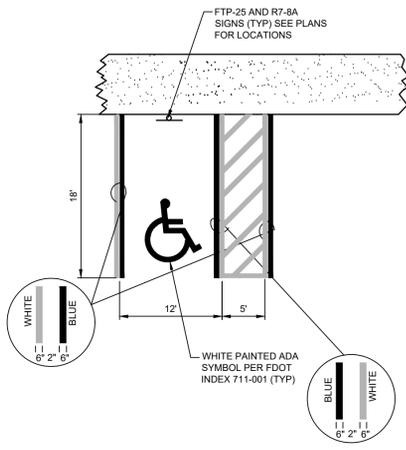

ADA PARKING STRIPING DETAIL
N.T.S.

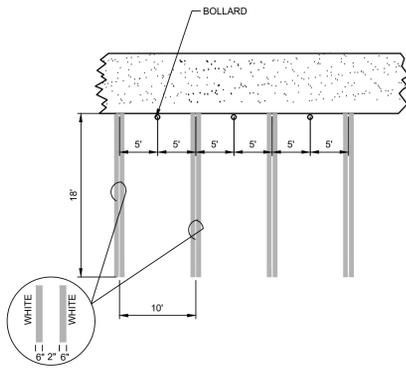

REGULAR PARKING STRIPING DETAIL
N.T.S.

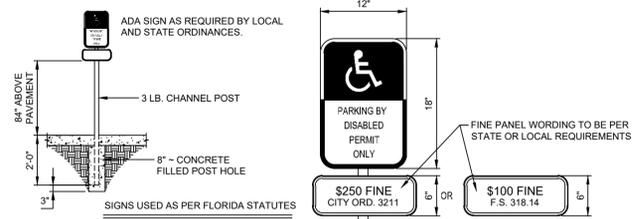


SIGNS USED AS PER FLORIDA STATUTES
FTP-25-04 PER FS 316.1955, FS 316.1956

SUPPLEMENTAL PANEL TO BE USED AS PER LOCAL REQUIREMENTS WHEN NEEDED.

NOTES: (HANDICAP SIGN ONLY)

1. THE SIGN'S FACE SHALL BE OF AN ENGINEERING GRADE REFLECTORIZED MATERIAL.
2. ALL LETTERS ARE 1 INCH SERIES "C" PER THE MUTCD.
3. THE TOP PORTION OF THE SIGN SHALL HAVE A BLUE BACKGROUND WITH A WHITE LEGEND AND BORDER.
4. THE BOTTOM PORTION OF THE SIGN SHALL HAVE A WHITE BACKGROUND WITH A BLACK OPAQUE LEGEND AND BORDER.
5. THE FINE NOTIFICATION SIGN SHALL HAVE A WHITE BACKGROUND WITH A BLACK OPAQUE LEGEND AND BORDER.
6. ONE SIGN SHALL BE REQUIRED FOR EACH PARKING SPACE.
7. EACH SIGN SHALL HAVE A CLEARANCE OF 7 FEET FROM THE BOTTOM OF THE SIGN TO FINAL GRADE OR THE TOP OF CURB, WHICHEVER IS GREATER. SIGNS SHALL NOT BE FARTHER THAN 5 FEET FROM THE FRONT OF THE PARKING SPACE.
8. ALL SIGNS SHALL BE MOUNTED ON 3 POUND CHANNEL POSTS. SIGNS MAY BE MOUNTED ON BUILDINGS WITH CITY APPROVAL.


ACCESSIBLE SIGN
N.T.S.

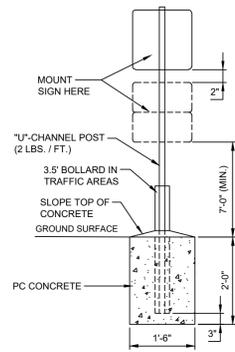


NOTE:

ALL SIGNS SHALL COMPLY WITH U.S. DEPARTMENT OF TRANSPORTATION, FEDERAL HIGHWAY ADMINISTRATION'S "MANUAL ON UNIFORM TRAFFIC CONTROL DEVICES" LOCAL CODES AND AS SPECIFIED. MOUNT SIGNS TO POST IN ACCORDANCE WITH MANUFACTURER'S INSTRUCTIONS.


STANDARD SIGN BASE
N.T.S.

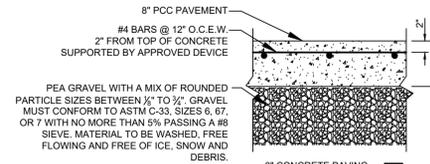

8" PCC PAVEMENT
#4 BARS @ 12" O.C.E.W.
2" FROM TOP OF CONCRETE
SUPPORTED BY APPROVED DEVICE

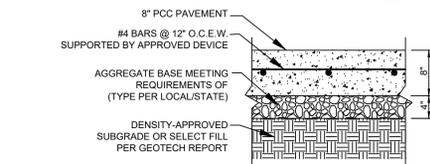

8" PCC PAVEMENT
#4 BARS @ 12" O.C.E.W.
SUPPORTED BY APPROVED DEVICE

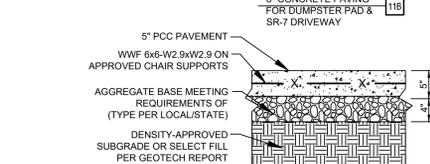

5" PCC PAVEMENT
WWF 6x6-W2.9xW2.9 ON
APPROVED CHAIR SUPPORTS


AGGREGATE BASE MEETING
REQUIREMENTS OF
(TYPE PER LOCAL/STATE)

DENSITY-APPROVED
SUBGRADE OR SELECT FILL
PER GEOTECH REPORT

5" CONCRETE PAVING


CONCRETE PAVING

NOTE:
1. CONCRETE SHALL BE 4,000 PSI COMPRESSIVE STRENGTH.
2. SEE SHEET C-13 FOR CONCRETE SPECIFICATIONS.


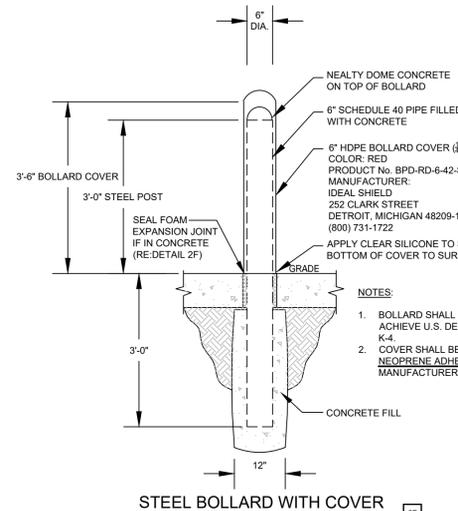


- NEALTY DOME CONCRETE ON TOP OF BOLLARD
- 6" SCHEDULE 40 PIPE FILLED WITH CONCRETE
- 6" HDPE BOLLARD COVER (1/2" TH.)
COLOR: RED
PRODUCT No. BPD-RD-6-42-S
MANUFACTURER:
IDEAL SHIELD
252 CLARK STREET
DETROIT, MICHIGAN 48209-1355
(800) 731-1722
- APPLY CLEAR SILICONE TO SEAL BOTTOM OF COVER TO SURFACE
- SEAL FOAM-EXPANSION JOINT IF IN CONCRETE (RE:DETAIL 2F)
- CONCRETE FILL
- NOTES:
1. BOLLARD SHALL BE CONSTRUCTED TO ACHIEVE U.S. DEPT. OF STATE RATING OF K-4.
2. COVER SHALL BE SECURED TO POST WITH NEOPRENE ADHESIVE TAPE PER MANUFACTURER'S RECOMMENDATIONS.


STEEL BOLLARD WITH COVER
N.T.S.

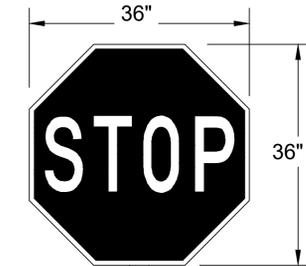

FDOT STOP SIGN
N.T.S.

  

BICYCLE RACK DETAIL
N.T.S.

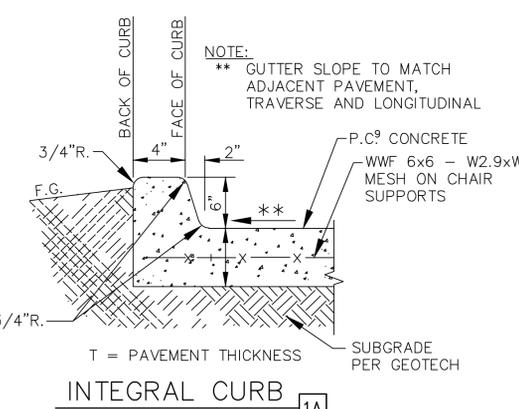


INTEGRAL CURB
N.T.S.

LUMINAIRE SCHEDULE								
MOUNTING CONFIG	SYMBOL	QTY	ASSEMBLY HEIGHT	POLE HEIGHT	LUMENS	TOTAL WATTS	MODEL NUMBER	DESCRIPTION
S		6	26'-0"	24'-0"	18904	135	SLM-18L-SIL-FT-UNV-50-70-BRZ	LSI LIGHTING, SLICE MEDIUM LED SERIES AREA LIGHT, 18,000 LUMENS PACKAGE, 5000K 70 CRI, SINGLE HEAD FLAT LENS FIXTURE, FORWARD THROW
D180		1	26'-0"	24'-0"	18904	270	SLM-18L-SIL-FT-UNV-50-70-BRZ	LSI LIGHTING, SLICE MEDIUM LED SERIES AREA LIGHT, 18,000 LUMENS PACKAGE, 5000K 70 CRI, DOUBLE HEAD FLAT LENS FIXTURE, FORWARD THROW
CANOPY		18	15'-0"	N/A	19071	152	CRUS-SC-LED-HO-50-UE-WHT	LSI LIGHTING, LEGACY SERIES, HIGH OUTPUT DRIVER, FLAT LENS CANOPY FIXTURE
H		2	8'-3"	N/A	4124	30	XWM 3 LED 04L 50 UE BRZ	LSI LIGHTING, MIRADA (XWM) WALL MOUNT LUMINAIRE, 5000K CCT, 4000 LUMEN PACKAGE, BRONZE COLOR, H-BB WITH BATTERY BACK-UP
H-BB		1	8'-3"	N/A	4124	30	XWM 3 LED 04L 50 UE BRZ BB	LSI LIGHTING, MIRADA (XWM) WALL MOUNT LUMINAIRE, 5000K CCT, 4000 LUMEN PACKAGE, BRONZE COLOR, H-BB WITH BATTERY BACK-UP
J		2	8'-8"	N/A	2333	22	LCD6LED25LUNVDIM135WF TR6RWWHAZ EM	LSI LIGHTING, LCD6 DOWN LIGHT LUMINAIRE, 3500K CCT, 2500 LUMENS, WIDE FLOOD HAZE SEMI-DIFFUSED WALL WASH REFLECTOR, WHITE OR EQUIVALENT


NOTES: ALL AREA SITE LIGHT FIXTURES AND POLES TO BE MOUNTED ON CONCRETE BASE PER DETAIL, THIS SHEET
ALL ANCHOR BOLTS TO BE ORIENTED IN THE SAME DIRECTION (SQUARE) AT INSTALLATION PER MANUFACTURER'S SPECIFICATIONS.
ALL PROPOSED FIXTURES ARE FULL CUT-OFF FIXTURES

POLE SCHEDULE				
MOUNTING CONFIG	SYMBOL	QTY	POLE HEIGHT	DESCRIPTION
S		6	24'-0"	4SQB3-S11G-24-S-BRZ-4BC
D180		1	24'-0"	4SQB3-S11G-24-D180-BRZ-4BC

NOTES: ALL AREA SITE LIGHT FIXTURES AND POLES TO BE MOUNTED ON CONCRETE BASE PER DETAIL, THIS SHEET

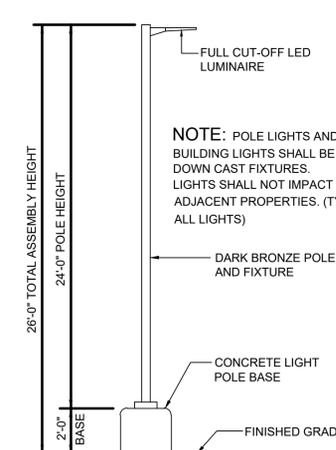

AREA LIGHT DETAIL
SCALE: NOT TO SCALE

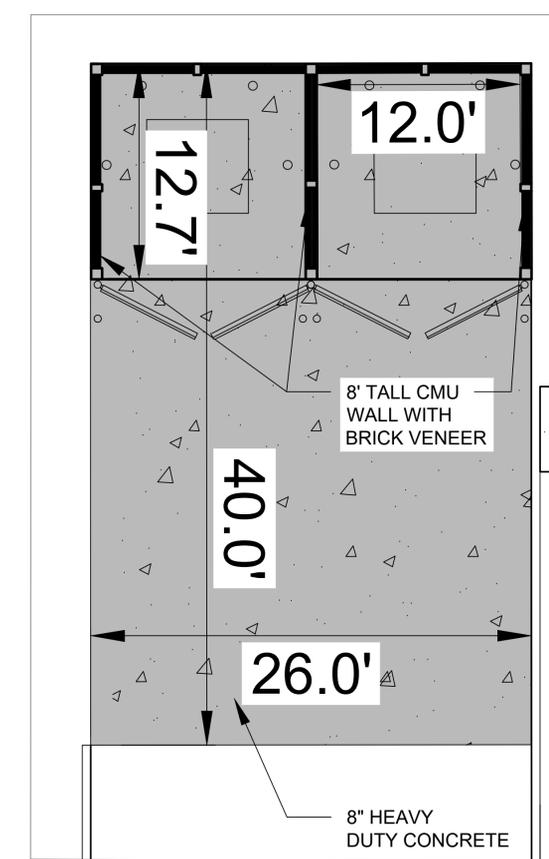

DUMPSTER ENCLOSURE DETAIL
N.T.S.

SHEET NO. C-3.1

PROFESSIONAL ENGINEER
No. 95482
STATE OF FLORIDA

June 08, 2023
ANDREW M. DEEGAN, P.E.
FL. P.E. No. 95482

JOB NO. M3689
Concept 1.0

REV-2
DATE: 6/8/23
J.C.H. DRW
A.M.D. DES
A.M.D. PM
T.H.H. PRN
DATE: 6/8/23

SEU CONCEPTUAL SITE PLAN 2 OF 2
MURPHY USA
10575 US HWY 1
PORT SAINT LUCIE FLORIDA

gph
www.cphcorp.com

A Full Service A & E Firm

Architects
Engineers
Environmental
Landscape Architects
M / E / P
Planners
Surveyors
Traffic / Transportation

Plans Prepared By:
CPH, Inc.
1992 SW 1st Street
Miami, FL 33135
Ph: 305.274.4805
Licenses:
Eng. C.O.A. No. 3215
Survey L.B. No. 7143
Arch. Lic. No. AA2600926
Landscape Lic. No. LC0000298

MURPHY OIL USA, INC.

MURPHY USA

200 PEACH STREET
EL DORADO, AR 71731-7000

J:\M3689\Civil\DWG\Current_Plan_Sett\Working\C-3 Site plan.dwg Jun 08, 2023 - 4:42pm adeegan